




2 HATCH DETAIL
 03 N.T.S.

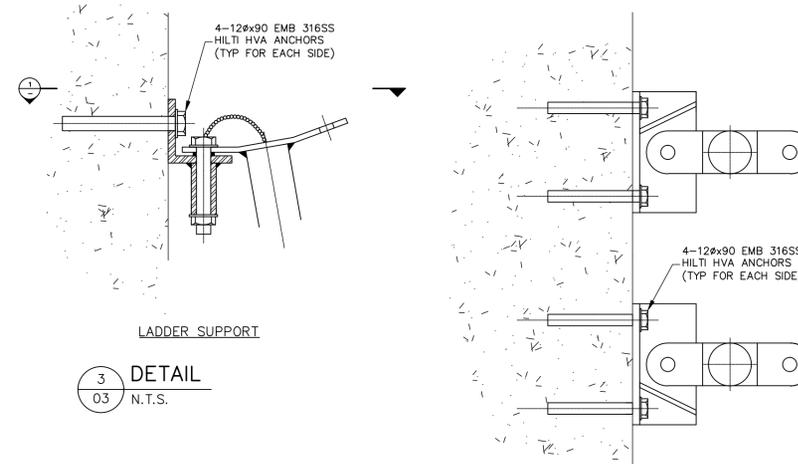

1 SECTION
 N.T.S.

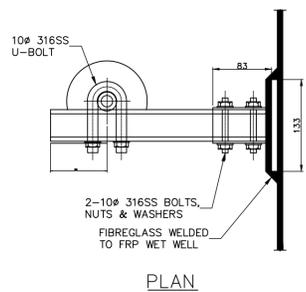

PLAN

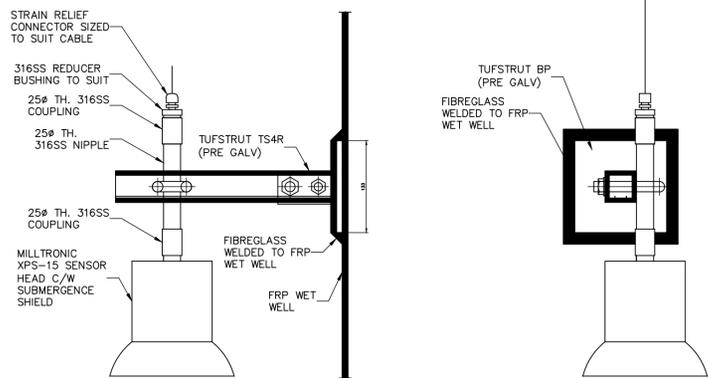


SIDE ELEVATION

BACK VIEW


MILLTRONICS LEVEL SENSOR

4 DETAIL
 03 N.T.S.

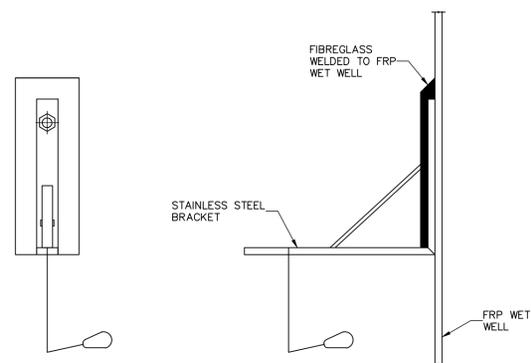


HIGH LEVEL FLOAT SWITCH SUPPORT

5 DETAIL
 03 N.T.S.

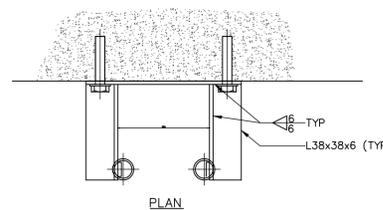

PLAN

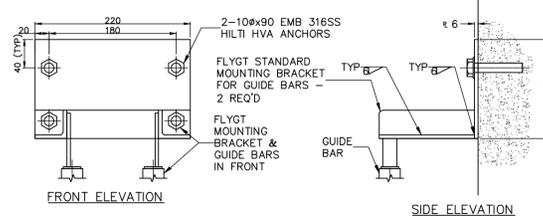


FRONT ELEVATION

SIDE ELEVATION

GUIDE BARS SUPPORT

6 DETAIL
 03 N.T.S.

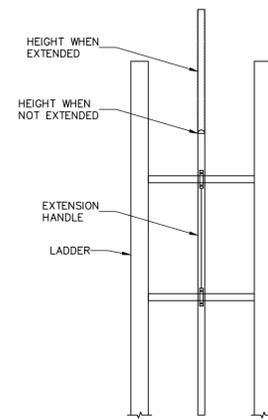

LADDER EXTENSION HANDLE

7 DETAIL
 N.T.S.

DELCAN No. EB - 3757



City of Richmond
 6911 NO. 3 ROAD RICHMOND B.C. V6Y 2C1

B.C. GAS SERVICES
 THE DEVELOPER OR CONTRACTOR SHALL BE RESPONSIBLE FOR DETERMINING EXISTING LOCATION OF GAS SERVICE LINES, AND WHERE NECESSARY ARRANGE FOR THEIR RELOCATION IN ORDER TO FACILITATE INSTALLATION OF THE WORKS SHOWN ON THESE PLANS. A LIST OF SERVICE LINE LOCATIONS MAY BE OBTAINED FROM:
B.C. ONE CALL
 TELEPHONE 1-800-474-6886 or Callar at *6886
 www.bcneccall.bc.ca
 NOTE - B.C. GAS REQUIRES 10 DAYS NOTICE PRIOR TO THE COMMENCEMENT OF ANY WORK.

BENCHMARK
 ALL ELEVATIONS ARE TO GEODETIC DATUM AND REFER TO RICHMOND BENCHMARK NUMBER:
 SURVEY CONTROL MONUMENT 77H4799
 INTERSECTION RYAN ROAD & NO 3 ROAD
 # _____
 ELEVATION 1.659 FIELD BOOK # _____
 CITY WORK ORDER # _____ TENDER / PROJECT # _____
 CONTRACTOR WORK ORDER # _____ ACCOUNT # _____

REFERENCE DRAWINGS

PROPERTY ACQUISITION	Aq	_____
SURVEY PLAN & PROFILE	PP	_____
ROAD CONSTRUCTION	Oc	_____
STORM SEWER INSTALLATION	Lc	_____
WATERMAIN INSTALLATION	Wc	_____
ORNAMENTAL STREET LIGHTING	Tc	_____
TRAFFIC SIGNALS	Ec	_____
SANITARY SEWER INSTALLATION	_____	_____
OTHER	_____	_____

NOTE - PROVE LOCATION OF ALL UTILITIES / SERVICES BEFORE STARTING CONSTRUCTION.


Nº	DATE	BY	CH.	DESCRIPTION
A	2012-11-06	MTS	SH	FOR PRE-PURCHASE
H				
G				
F				
E				
D				
C				
B				

REVISIONS



TITLE: MONTROSE SANITARY PUMP STATION UPGRADE

DETAILS

DESIGN: BD	DWG. Nº: 3346-08-00
DRAWN: MTS	
CHECKED: CK	SCALE: 1:20
ENGINEER: SH	DATE: OCTOBER 2012
	SEC. Nº: _____
	SHT. Nº: 06 OF 06

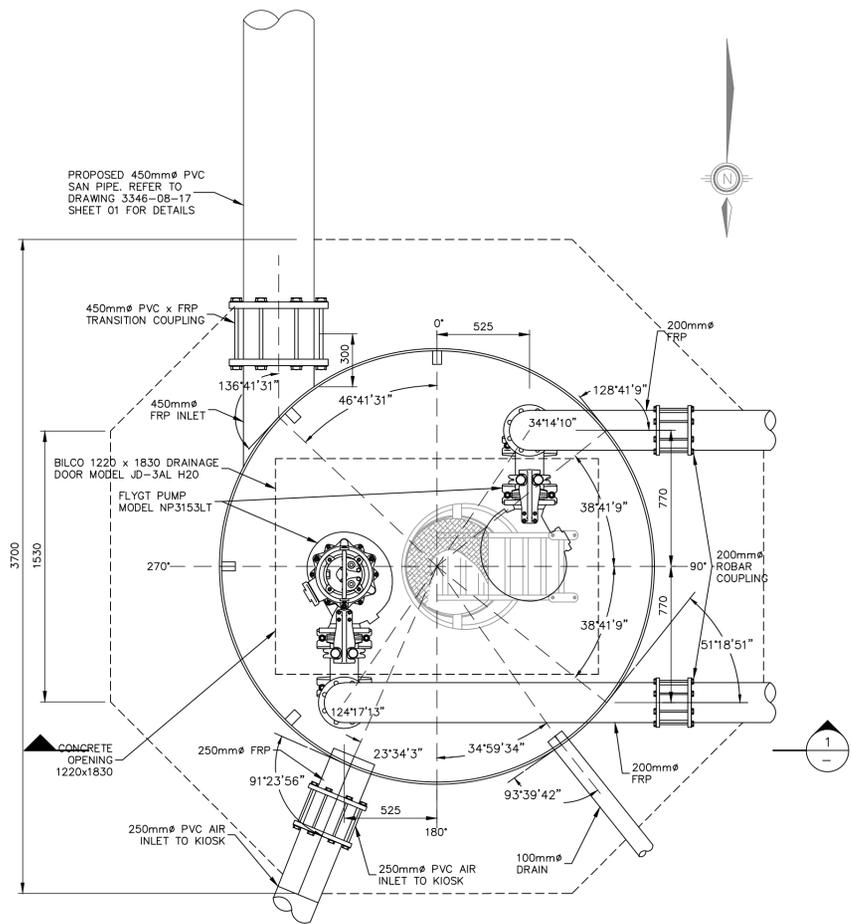

PLAN - WET WELL
1:20

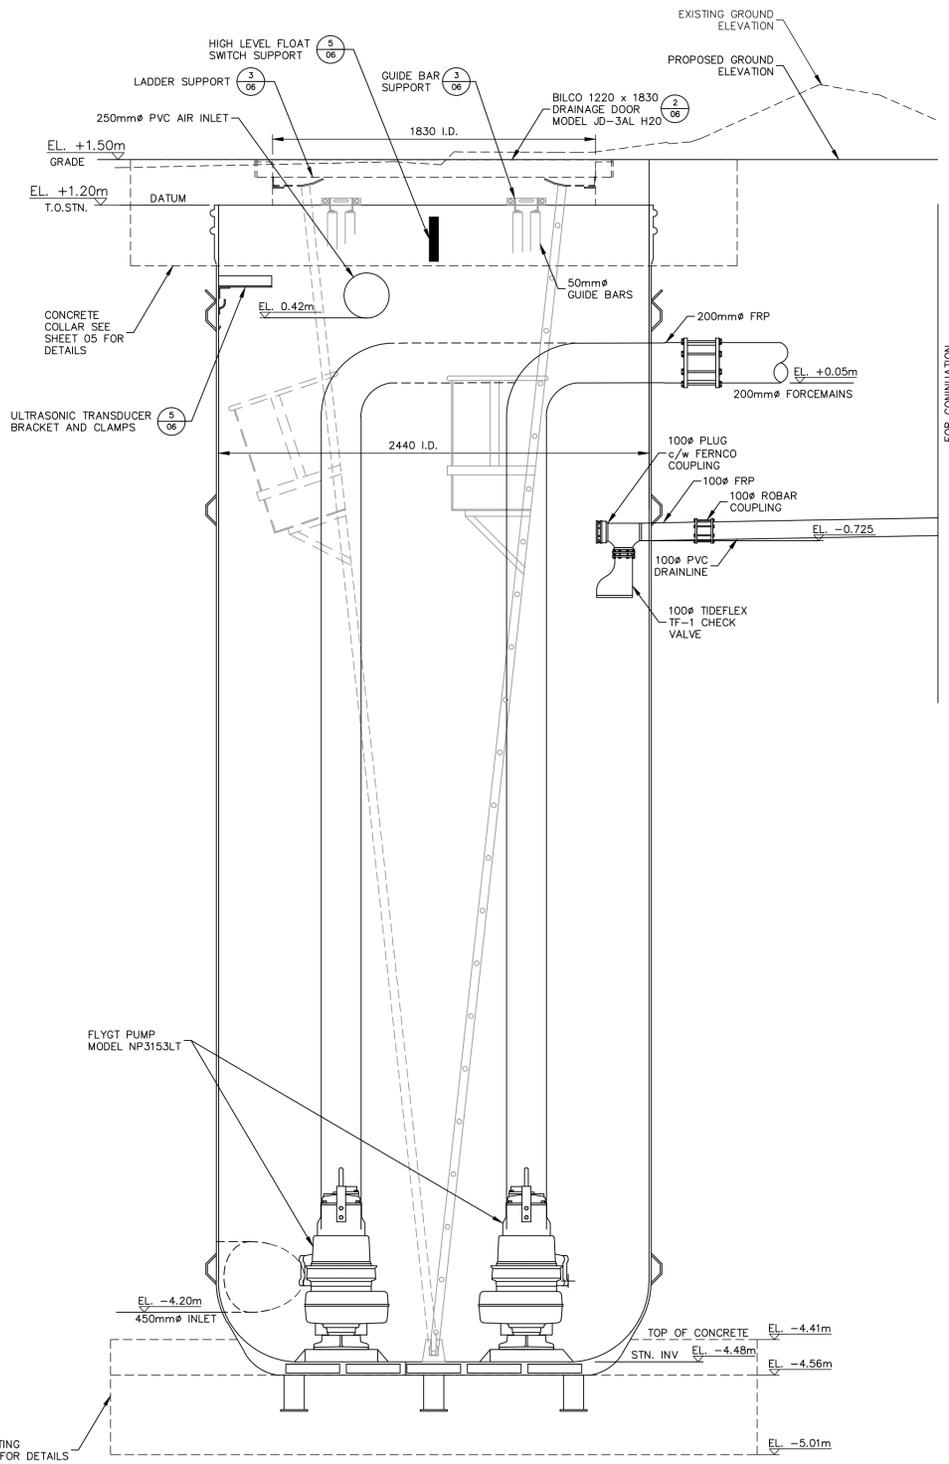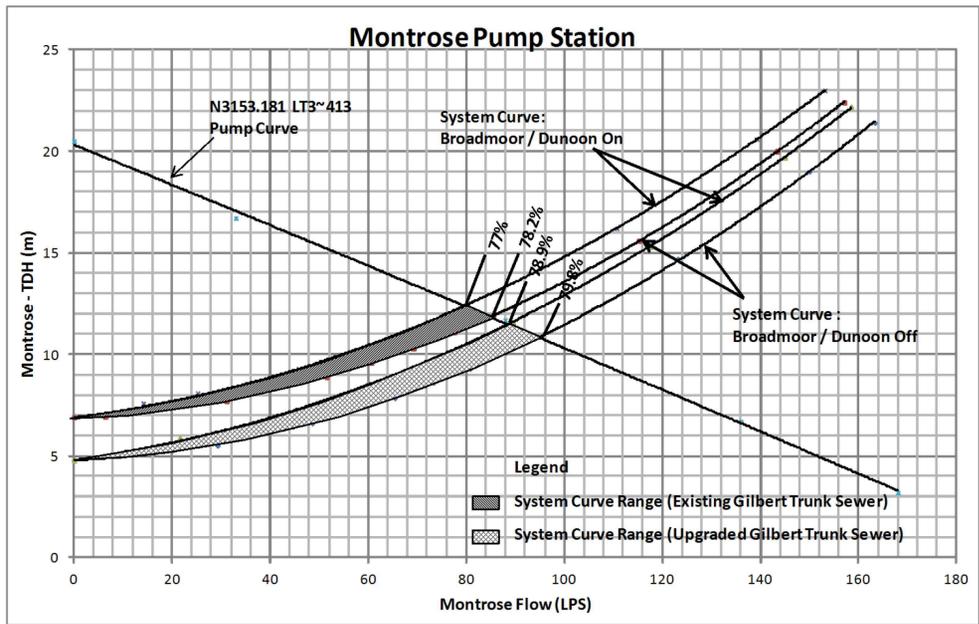

SECTION

DELSCAN No. EB-3757



City of Richmond
6911 No. 3 Road Richmond B.C. V6Y 2C1

B.C. GAS SERVICES
THE DEVELOPER OR CONTRACTOR SHALL BE RESPONSIBLE FOR DETERMINING EXISTING LOCATION OF GAS SERVICE LINES, AND WHERE NECESSARY ARRANGE FOR THEIR RELOCATION IN ORDER TO FACILITATE INSTALLATION OF THE WORKS SHOWN ON THESE PLANS. A LIST OF SERVICE LINE LOCATIONS MAY BE OBTAINED FROM:
B.C. ONE CALL
TELEPHONE 1-800-474-6886 or Cellar at *6886
www.bcneccall.bc.ca
NOTE - B.C. GAS REQUIRES 10 DAYS NOTICE PRIOR TO THE COMMENCEMENT OF ANY WORK.

BENCHMARK
ALL ELEVATIONS ARE TO GEODETIC DATUM AND REFER TO RICHMOND BENCHMARK NUMBER:
SURVEY CONTROL MONUMENT 77H4799
INTERSECTION RYAN ROAD & NO 3 ROAD
ELEVATION 1.659 FIELD BOOK N° _____
CITY WORK ORDER N° _____ TENDER / PROJECT N° _____
CONTRACTOR WORK ORDER N° _____ ACCOUNT N° _____

REFERENCE DRAWINGS
PROPERTY ACQUISITION Aq _____
SURVEY PLAN & PROFILE PP _____
ROAD CONSTRUCTION Oc _____
STORM SEWER INSTALLATION Lc _____
WATERMAIN INSTALLATION Wc _____
ORNAMENTAL STREET LIGHTING Tc _____
TRAFFIC SIGNALS Ec _____
SANITARY SEWER INSTALLATION _____
OTHER _____
NOTE - PROVE LOCATION OF ALL UTILITIES / SERVICES BEFORE STARTING CONSTRUCTION.

N°	DATE	BY	CH.	DESCRIPTION
B	2012-11-06	MTS	SH	FOR PRE-PURCHASE
A	2012-09-17	KS	TDB	90% DESIGN

DESIGN: BD
DRAWN: KS
CHECKED: CK
ENGINEER: SH

TITLE: MONTROSE SANITARY PUMP STATION UPGRADE
WET WELL DETAILS
DWG. N°: 3346-08-00
SCALE: 1:20
DATE: DECEMBER 2011
SHT. N°: 03 OF 06